

GENERAL LIGHTING NOTES

1. IT IS THE RESPONSIBILITY OF THE CONTRACTOR TO REVIEW ALL OF THE DRAWINGS AND SPECIFICATIONS ASSOCIATED WITH THIS PROJECT WORKSCOPE PRIOR TO THE INITIATION OF CONSTRUCTION. SHOULD THE CONTRACTOR FIND A CONFLICT WITH THESE DOCUMENTS, REFER TO THE SPECIFICATIONS AS DEFINED IN THE CONTRACT DOCUMENTS. THE CONTRACTOR IS TO NOTIFY THE PROJECT ENGINEER OR READER IN WRITING PRIOR TO THE START OF CONSTRUCTION. FAILURE BY THE CONTRACTOR TO NOTIFY THE PROJECT ENGINEER TO COMPLETE THE SCOPE OF WORK AS DEFINED BY THE DRAWINGS AND IN FULL CONFORMANCE WITH LOCAL REGULATIONS AND CODES.

2. ALL WORK SHALL CONFORM TO THE TOWN OF BETHLEHEM, ALBANY COUNTY AND N.Y.S.D.O.T. CONSTRUCTION STANDARDS AS APPLICABLE.

3. IT SHALL BE THE CONTRACTOR'S RESPONSIBILITY TO NOTIFY "THE NEW YORK ONE CALL SYSTEM" (1-800-962-7962) 72 HOURS PRIOR TO ANY EXCAVATION ON THIS SITE. CONTRACTOR SHALL ALSO NOTIFY LOCAL WATER & SEWER DEPARTMENTS TO MARK OUT THEIR UTILITIES.

4. LOCATION OF ALL EXISTING AND PROPOSED SERVICES ARE APPROXIMATE AND MUST BE CONFIRMED INDEPENDENTLY WITH LOCAL UTILITY COMPANIES PRIOR TO COMMENCEMENT OF ANY CONSTRUCTION OR EXCAVATION. ALL UTILITY SERVICE CONNECTION POINTS SHALL BE CONFIRMED INDEPENDENTLY BY THE CONTRACTOR IN THE FIELD PRIOR TO THE COMMENCEMENT OF CONSTRUCTION.


5. ALL UTILITY LOCATIONS ARE APPROXIMATE. IT IS THE RESPONSIBILITY OF THE CONTRACTOR TO LOCATE CONDUITS, PRODUCT PIPING, ETC. PRIOR TO COMMENCEMENT OF EXCAVATION OF ANY TYPE.

6. ANY REPRODUCTION OF THIS ENGINEERED DOCUMENT WITHOUT THE PRIOR CONSENT OF THE "ENGINEER OF RECORD" IS STRICTLY PROHIBITED.

7. IN CASE OF DISCREPANCIES BETWEEN PLANS, THE SITE PLAN WILL SUPERSEDE IN ALL CASES. NOTIFY ENGINEER OF RECORD OF ANY CONFLICTS.

Statistical Area Summary

Label	Avg	Max	Min	Avg/Min	Max/Min
CANOPY	33.6	51.9	10.8	3.11	4.81
INSIDE CURB	6.14	51.9	0.2	30.7	259.5

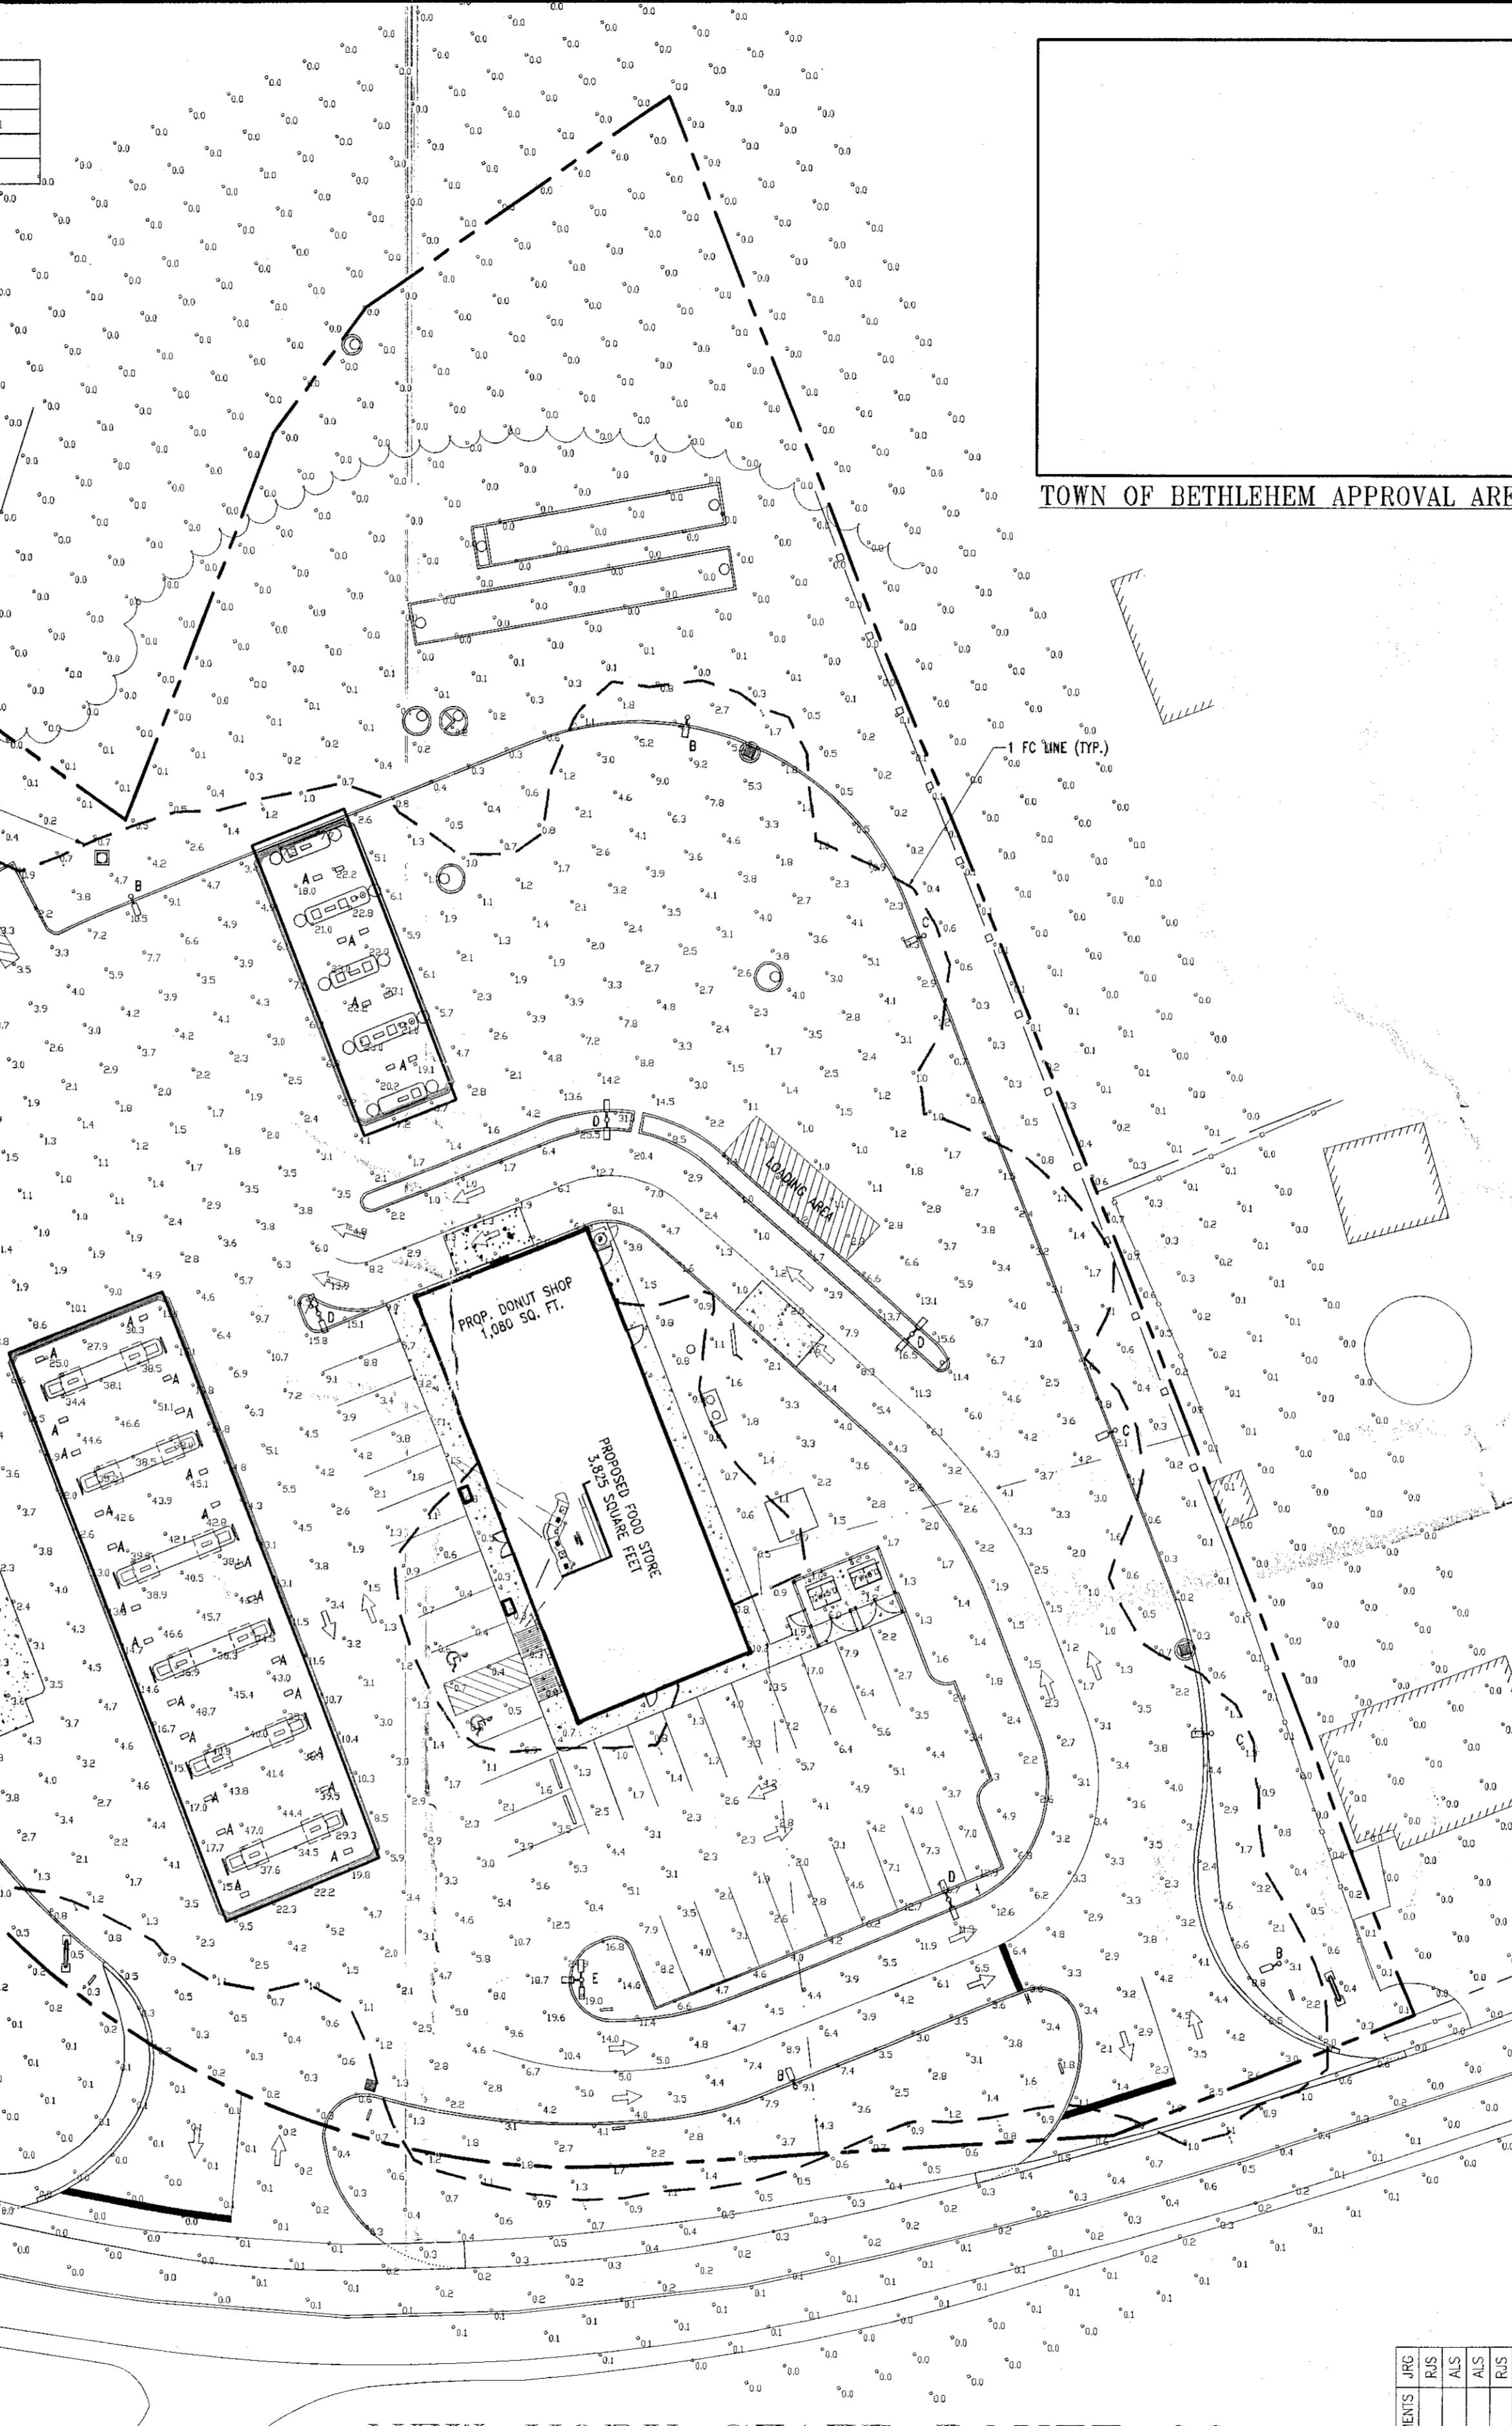

NEW YORK STATE ROUTE 32


(A.K.A. CORNING HILL ROAD, STATE HIGHWAY #5499)
(F.K.A. ALBANY-BETHLEHEM TURNPIKE)

(VARIABLE WIDTH)


LUMINAIRE SCHEDULE							
SYMBOL	QUANTITY	LABEL	ARRANGEMENT	LUMENS	LLF	DESCRIPTION	TOT. WATTS
□	28	A	SINGLE	26,000	0.720	RIC-S-250-SMH-73	320
□	8	B	SINGLE	40,000	0.720	CHH-FT-400-MH-F	458
□	3	C	SINGLE	40,000	0.720	CHH-FT-400-MH-F-3HSS	458
□□	4	D	DOUBLE	40,000	0.720	CHH-FT-400-MH-F	458
□□□	1	E	TRIPLE	40,000	0.720	CHH-FT-400-MH-F	458

INCHES
Town of Bethlehem, NY


GRAPHIC SCALE
30 60 120
(IN FEET)
1 inch = 30 ft.

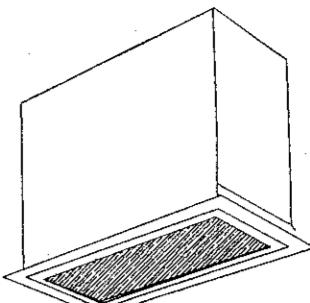


RICHMOND
CANOPY LIGHTING
RIC-S-250-SMH-73

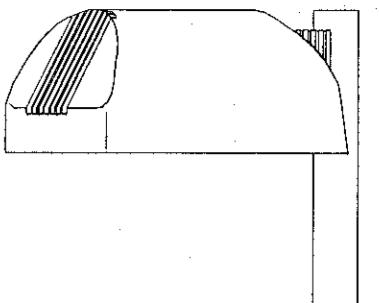


CHALLENGER
AREA LIGHTING
CHH-FT-400-MH-F

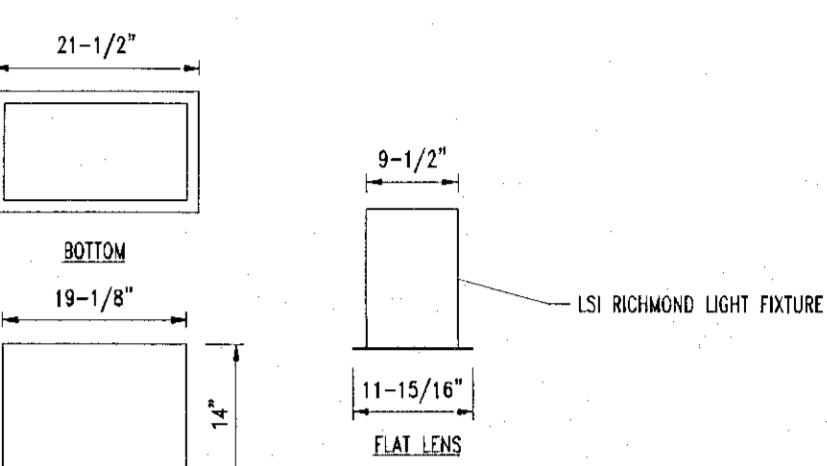

TYPICAL CANOPY LIGHT DETAIL
NOT TO SCALE

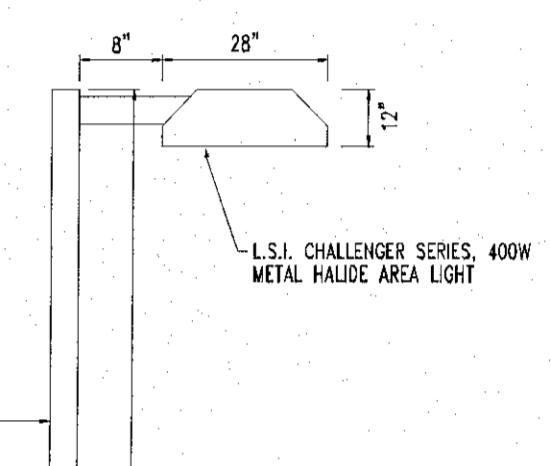

LSI CHALLENGER SERIES, 400W
METAL HALIDE AREA LIGHT

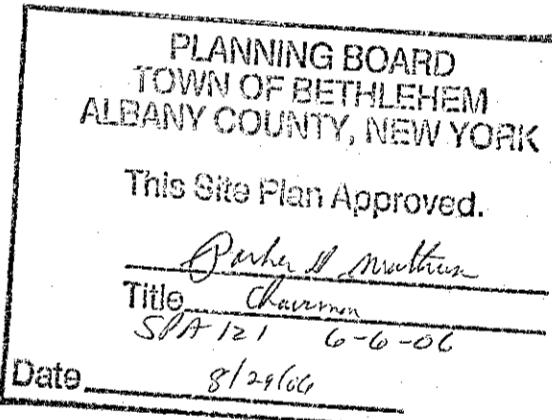

RECEIVED
AUG 28 2006
TOM. 3-21-121-121

Cumberland Farms	
777 Dedham Street, Canton, Massachusetts 02021	
BOHLER ENGINEERING, P.C.	
• CIVIL & CONSULTING ENGINEERS • PROJECT MANAGERS • ENVIRONMENTAL & SITE PLANNERS • MUNICIPAL ENGINEERS •	
352 TURNPIKE ROAD, SUITE 105 SOUTHBOROUGH, MA 01772	
5 COMPUTER DRIVE WEST, SUITE 203 ALBANY, NEW YORK 12205	
776 MOUNTAIN BLVD. WATCHUNG, NEW JERSEY 07060	
(518) 438-9900 (908) 668-6300	
PROJEC: CUMBERLAND FARMS, INC. PROP. FOOD STORE & GAS STATION 68 ROUTE 9W - NYS Rte 9W TOWN OF BETHLEHEM, ALBANY COUNTY, NEW YORK	
TITLE: LIGHTING PLAN	
L.H. BOHLER	
W.H. BOHLER	
Scales: (H) 1" = 30' (V) NONE	
DRAWN BY: SMV DRAWN BY: RJS DRAWN BY: RJS DRAWN BY: RJS	
DATE: 4/11/05 DATE: 4/11/05 DATE: 4/11/05 DATE: 4/11/05	
PROFESSIONAL ENGINEER NEW YORK STATE LICENSE No. 27418 PENNSYLVANIA LICENSE No. 07164 NEW YORK LICENSE No. 33406 CONNECTICUT LICENSE No. 17518 MASSACHUSETTS LICENSE No. 37025	
SHEET No: 9 OF 16	
REV. No: 6	
CONSTRUCTION CHECK DATE	