

HERSHBERG  
&  
HERSHBERG

Consulting Engineers  
and Land Surveyors

18 Locust Street  
Albany, New York 12203

ALTERATION OF THIS  
DOCUMENT EXCEPT BY A  
LICENSED PROFESSIONAL  
ENGINEER OR LAND  
SURVEYOR, IS ILLEGAL



REMARKS	DATE
BUILDING REDESIGN	3/21/03
LETTER DATED 4/23/08	4/30/08
LANDSCAPING & LIGHTING PLAN	5/14/03
REVIEW LETTER DATED 6/11/08	7/14/08
LANDSCAPING & BASEMENT ENTRY	5/14/09
EMAIL DATED 5/19/09	5/21/09

REVISIONS
07/03/08-1-DWG
DATE: 10/5/07
CHK: DRH

PROPOSED LANDSCAPING PLAN FOR
No. 48 HUDSON AVENUE
HAMLET OF DELMAR, TOWN OF BETHLEHEM
ALBANY COUNTY, STATE OF NEW YORK
SCALE: 1"=20'
07/03/08
DATE: 10/5/07
CHK: WM

RECEIVED  
JUN 16 2009  
PLANNING BOARD  
TOWN OF BETHLEHEM

TOWN OF BETHLEHEM PLANNING BOARD APPROVAL
PLANNING BOARD TOWN OF BETHLEHEM ALBANY COUNTY, NEW YORK
This Site Plan Approved.
For the record
SPA 146-A2
Date: June 22, 2009


FILE: 070303

SPA 146-A-2

FOR MUNICIPAL APPROVAL ONLY-NOT INTENDED FOR CONSTRUCTION

LEGEND

W	EXISTING WATER LINE
ST	EXISTING STORM SEWER
S	EXISTING SANITARY SEWER
MONUMENT	
IRON ROD	
MH	MANHOLE
X	FENCE LINE
POLE & GUY WIRE	
WATER SHUT OFF	
EXISTING DECIDUOUS TREE	
EXISTING CONIFEROUS TREE	
EXISTING SPOT ELEVATION	
PROPOSED PAVEMENT	
PROPOSED PAVEMENT MARKINGS	
HANDICAPPED PARKING	
PROPOSED CONCRETE WALK	
BB	PROPOSED CATCH BASIN
S	PROPOSED SANITARY SEWER
W	PROPOSED WATER MAIN
ST	PROPOSED STORM SEWER
RD	PROPOSED ROOF DRAIN
1/C4	DETAIL REFERENCE (DETAIL/SHEET)
+	PROPOSED LANDSCAPING

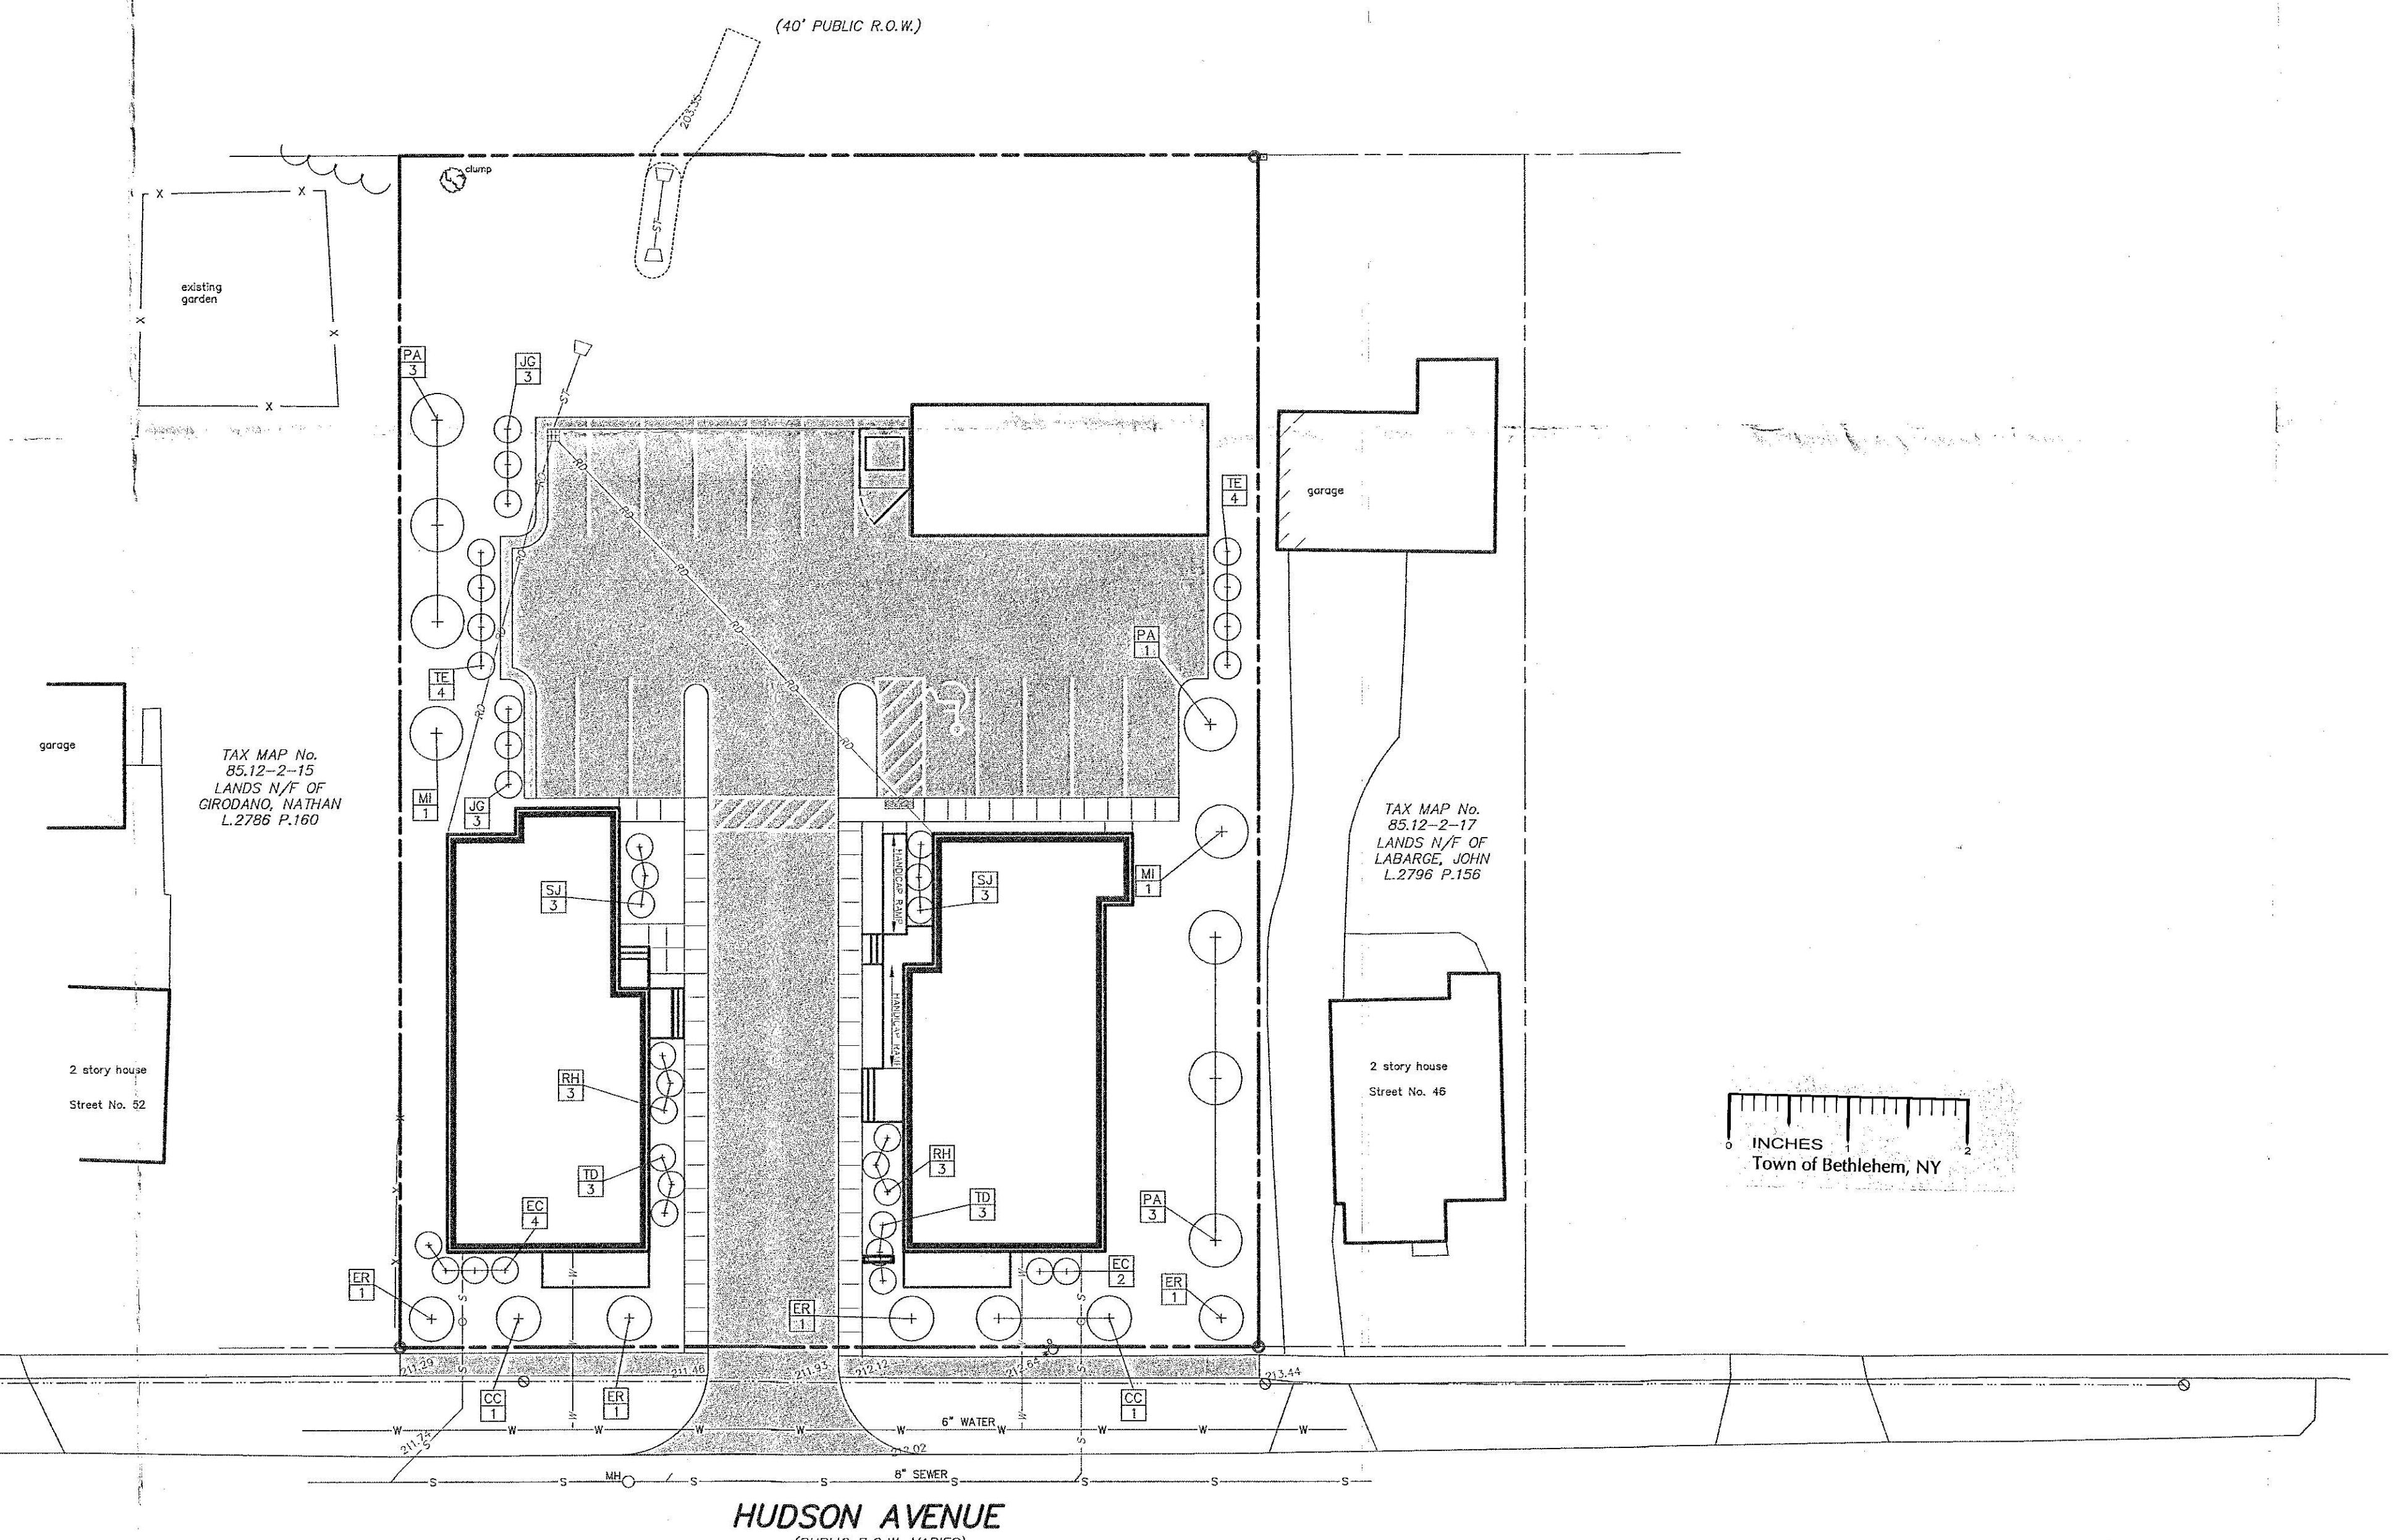

C6