



1 REVISED PER COMMENTS SKB 6/30/15
0 ISSUED FOR BP SKB 4/22/15
No. Submittal / Revision App'd Date
Drawn: SKB Date: 4/22/15
Designed: AJD Date: 4/22/15
Checked: AJD Date: 4/22/15
Project Number 168-117
Project Title

CELL TOWER

457 NYS ROUTE 85
SLINGERLANDS, NY 12159

Prepared For

Phoenix Towers LLC

110 WASHINGTON AVE
NORTH HAVEN, CT 06473
C: 203-232-3287

Drawing Title

GRADING, DRAINAGE,
& EROSION CONTROL
DETAILS


Drawing Scale: **CD**
Date: 6/30/15

TOWN OF BETHLEHEM, NEW YORK
PLANNING DEPT. ORIGINAL
- SCANNED -
0 1 INCHES 2

PLANNING BOARD
TOWN OF BETHLEHEM
ALBANY COUNTY, NEW YORK
By direction of the Chairman.
These drawings are hereby approved.
See sheet(s) *3 of 27* for date and signature.


Sheet Number:

25 OF 27

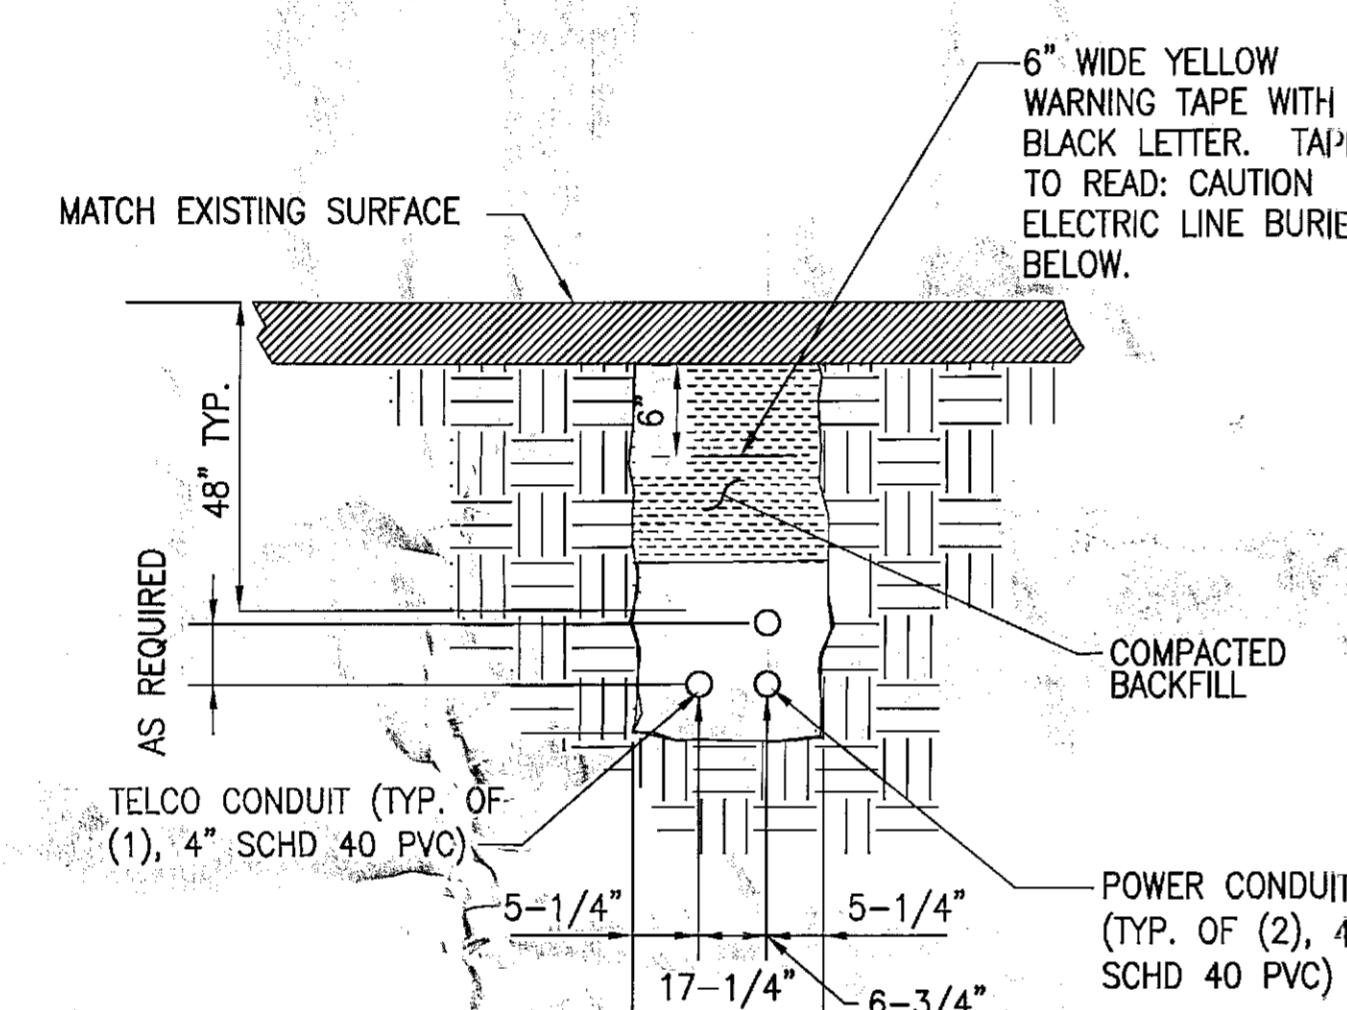

NOTE:
1. NUMBER AND SIZE OF CONDUITS MAY VARY. CONFIRM DIMENSIONS SHOWN WITH UTILITY COMPANY.
2. CONTRACTOR TO VERIFY IN FIELD THE LOCATION, SIZE, TYPE, AND DEPTH OF ALL EXISTING UNDERGROUND UTILITIES PRIOR TO DIGGING THE SERVICE TRENCH. PROVIDE A MINIMUM OF 18" CLEARANCE BETWEEN EXISTING UTILITIES AND EXISTING UTILITIES IN THE CASE OF UTILITY LINE CROSSINGS.

1 TYPICAL CONDUIT TRENCH DETAIL
--- NOT TO SCALE

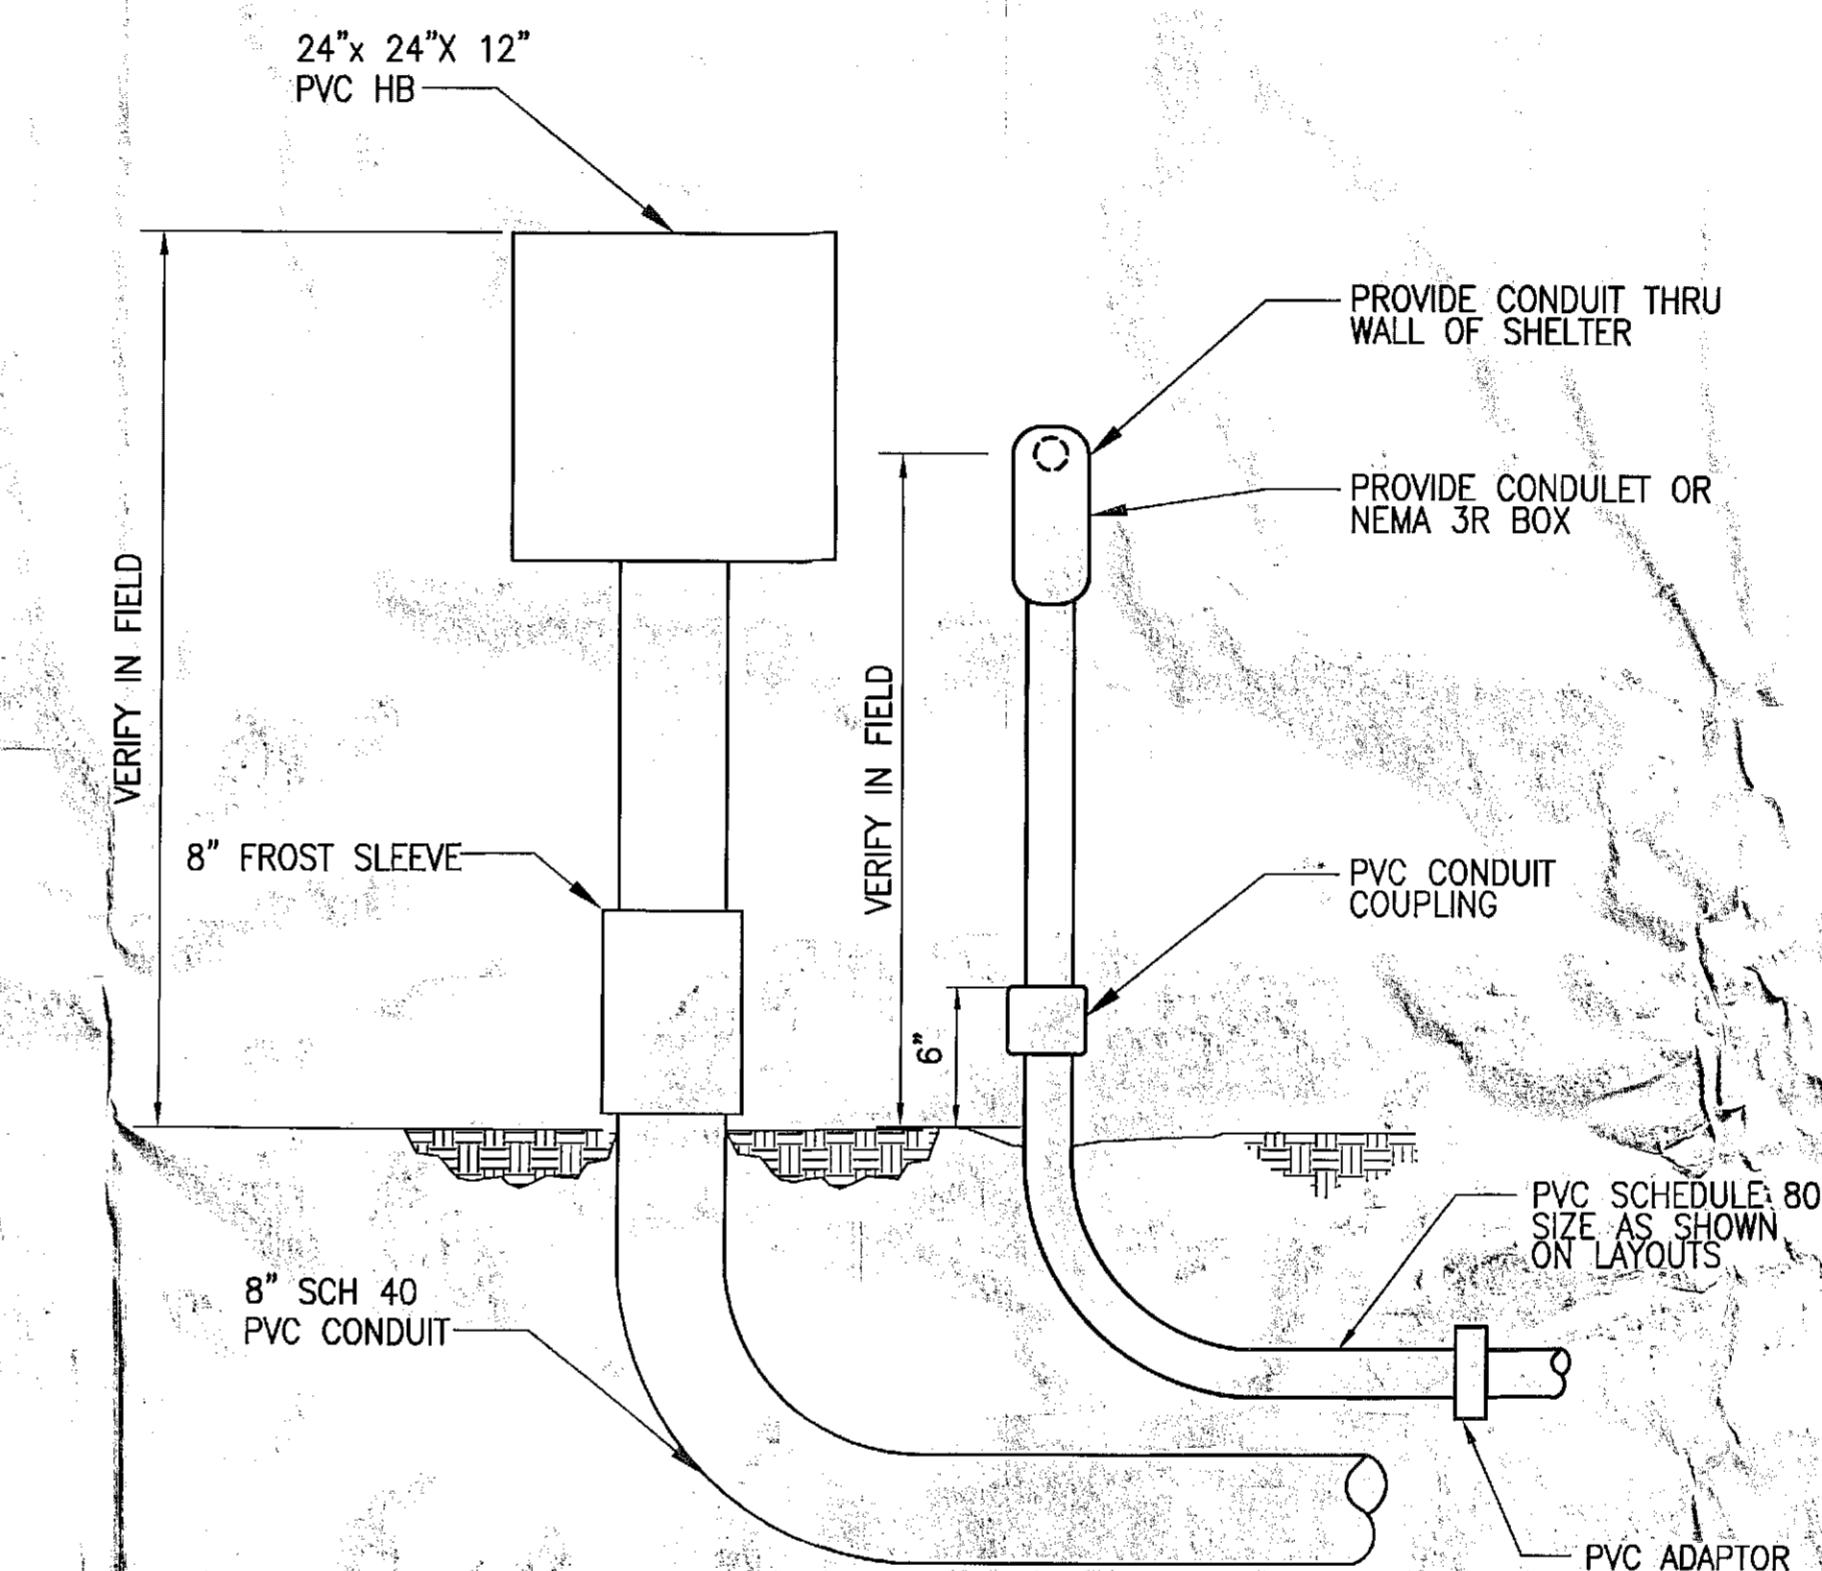

NOTE:
ALL CONDUIT ABOVE GRADE MUST BE RIGID STEEL.
ALL PVC SCH. 80 CONDUIT MUST HAVE MIN. BURIAL DEPTH.

2 UNDERGROUND CONDUIT STUB-UP (TELCO/POWER)
--- NOT TO SCALE